

NOT FOR CONSTRUCTION


NOTES  
Copyright of this drawing is reserved by HUTCHINSON ASSOCIATES.  
This drawing shall only be read in conjunction with all other relevant drawings.  
Liaise with all other trades for accurate co-ordination of services.  
Site check all dimensions before preparation of working drawing or commencement of work.  
This drawing is the property of HUTCHINSON ASSOCIATES and shall be returned at their request.  
This drawing shall not be used for any purpose without authority from HUTCHINSON ASSOCIATES.

### LEGEND


|                 |                                                        |
|-----------------|--------------------------------------------------------|
| DS              | SEWER DRAIN                                            |
| SRM             | SEWER RISING MAIN                                      |
| WC              | COLD WATER SERVICE                                     |
| AAV             | AIR ADMITTANCE VALVE                                   |
| CO              | CLEANOUT                                               |
| IV              | ISOLATION VALVE                                        |
| IFW             | INDUSTRIAL FLOOR WASTE GULLY                           |
| IO              | INSPECTION OPENING                                     |
| HC              | 15 HOSE COCK WITH VACUUM BREAKER ON WALL 600 ABOVE FFL |
| HDPE            | HIGH DENSITY POLYETHYLENE                              |
| RE              | ROD END                                                |
| RSC0            | RIISING SHAFT/CLEANOUT                                 |
| SIZE OF PIPE    |                                                        |
| 100 DS:60       |                                                        |
| GRADE OF PIPE   |                                                        |
| TYPE OF SERVICE |                                                        |

### NOTES

- REFER TO ARCHITECT DRAWINGS FOR EXACT LOCATION OF FLOOR WASTE, HWU, TAPWARE, ETC.
- PHYSICALLY VERIFY EXACT LOCATION OF EXISTING SERVICES ON SITE BEFORE COMMENCING ANY NEW WORK.
- RECHECK ALL NOMINATED INVERT LEVELS ON SITE TO AVOID CLASHES WITH STRUCTURAL ELEMENTS AND SERVICES OF OTHER TRADES BEFORE COMMENCING WORK.

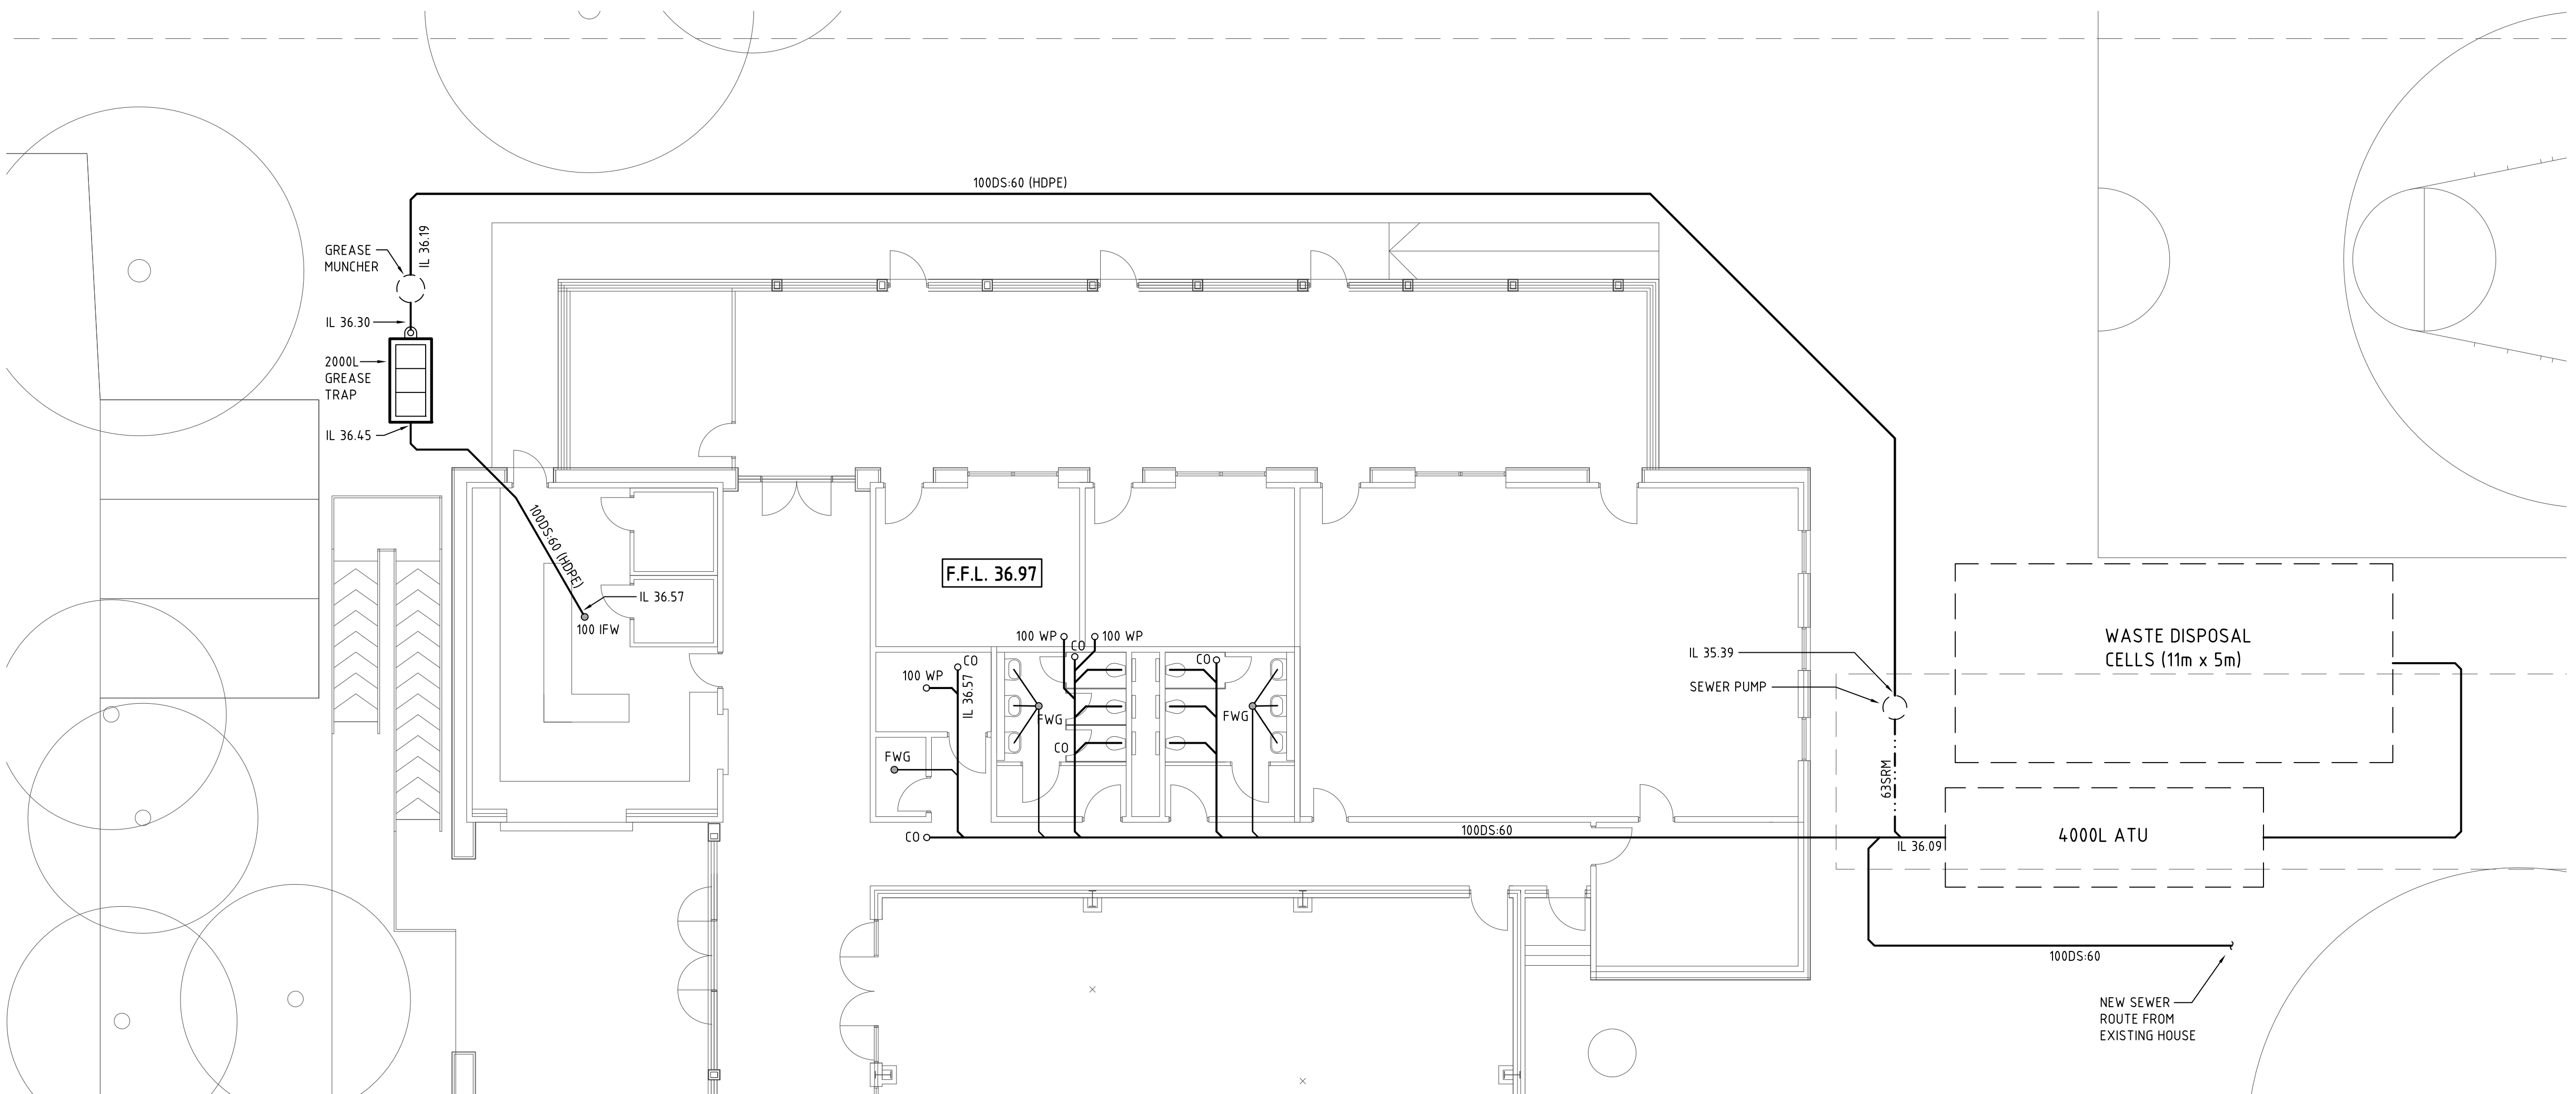

FLOOR PLAN

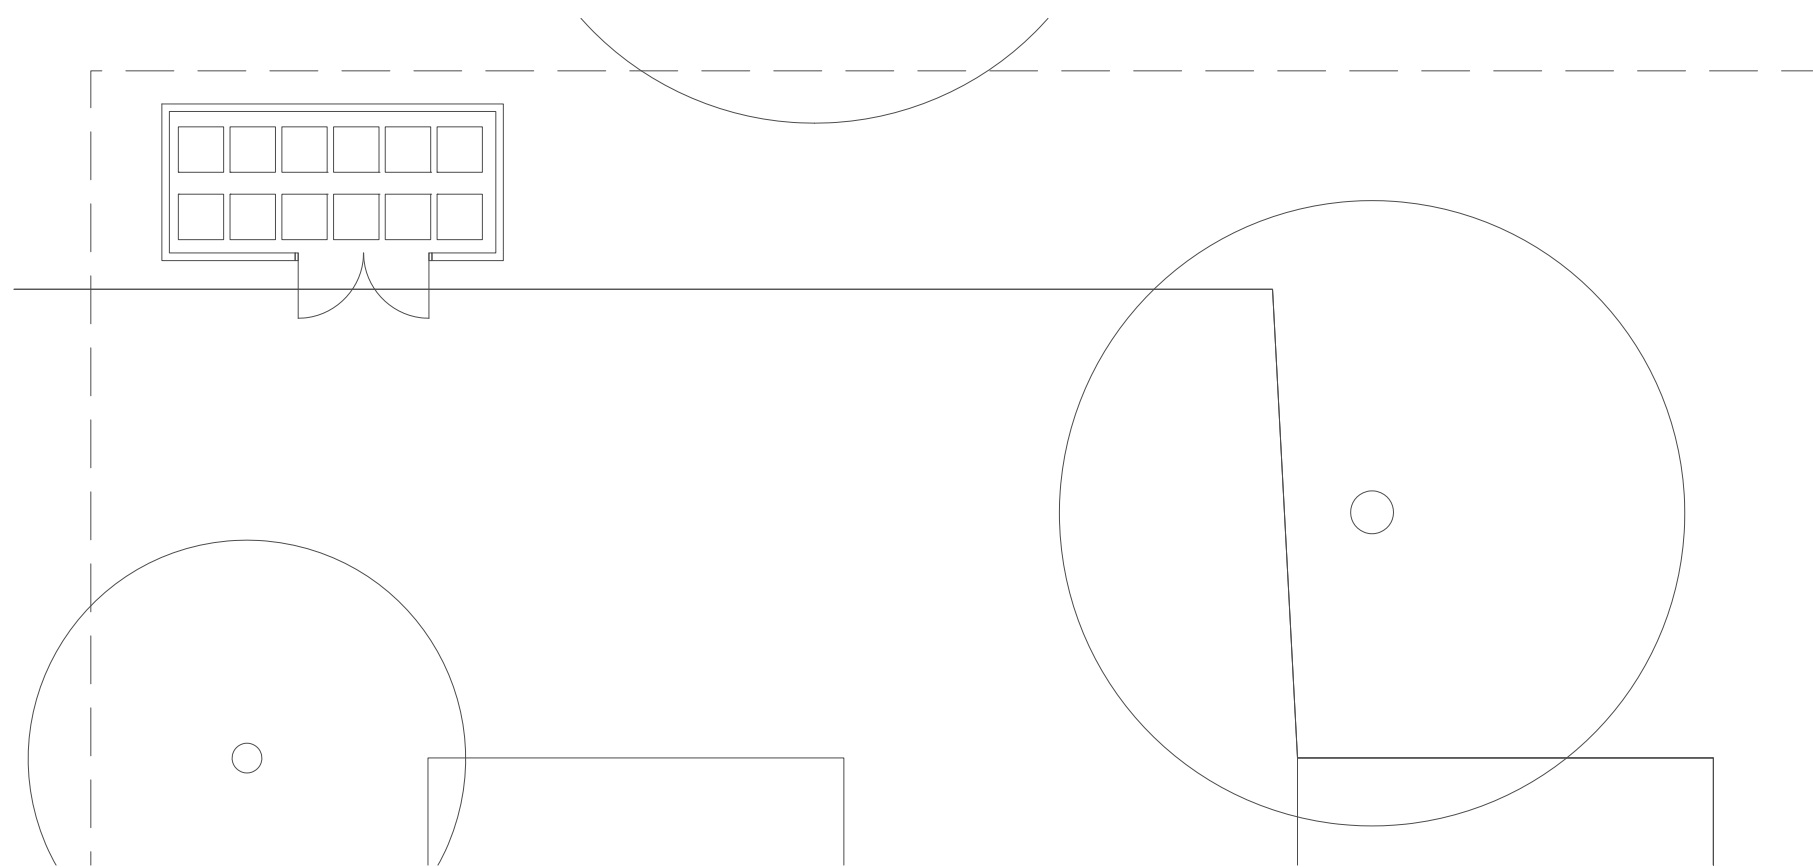

PART PLAN

|         |      |             |               |     |     |
|---------|------|-------------|---------------|-----|-----|
| 3       | -    | 27.06.17    | THIRD REVIEW  | JMD | MAH |
| 2       | -    | 20.06.17    | SECOND REVIEW | JMD | MAH |
| 1       | -    | 15.06.17    | FIRST REVIEW  | JMD | MAH |
| ISS/REV | DATE | DESCRIPTION | DSN           | APP |     |

Architect

**peter hunt architect**  
Email: pha@phunt.com.au  
8 COLIN GROVE, WEST PERTH, WA 6005  
TEL: (08) 9322 6033 FAX: (08) 9324 1691

Consultant

**Hutchinson Associates**  
international plumbing & hydraulic consultants  
187 Beaufort St. PERTH WA 6000  
Telephone: (61.8) 9328 9155  
Facsimile: (61.8) 9328 3266  
E-Mail: info@hutchass.com.au

Project Title

PLACE OF WORSHIP &  
COMMUNITY USE  
LOT 213 (28) LEWIS ROAD  
WATTLEGROVE

Drawing Title

HYDRAULIC SERVICES  
SEWER DRAINAGE

|             |        |             |       |          |     |  |
|-------------|--------|-------------|-------|----------|-----|--|
| Date        | JUNE17 | Drawn       | JMD   | Designed | JMD |  |
| Scale       | 1:100  | Sheet Size  | A1    | Checked  | MAH |  |
| Project No. | 72.17  | Drawing No. | SK-01 | Issue    | 3   |  |

7217H001.DWG 7/08/2017 9:42:53 AM

