


NOTE:
DRAWINGS HAVE BEEN PREPARED TO INDICATED SCALES AT
A1 SIZE. PRINTING AND COPYING CAN DISTORT SCALES.
THEREFORE DO NOT RELY ON SCALING OF DRAWINGS TO
OBTAIN SIZES AND QUANTITIES.

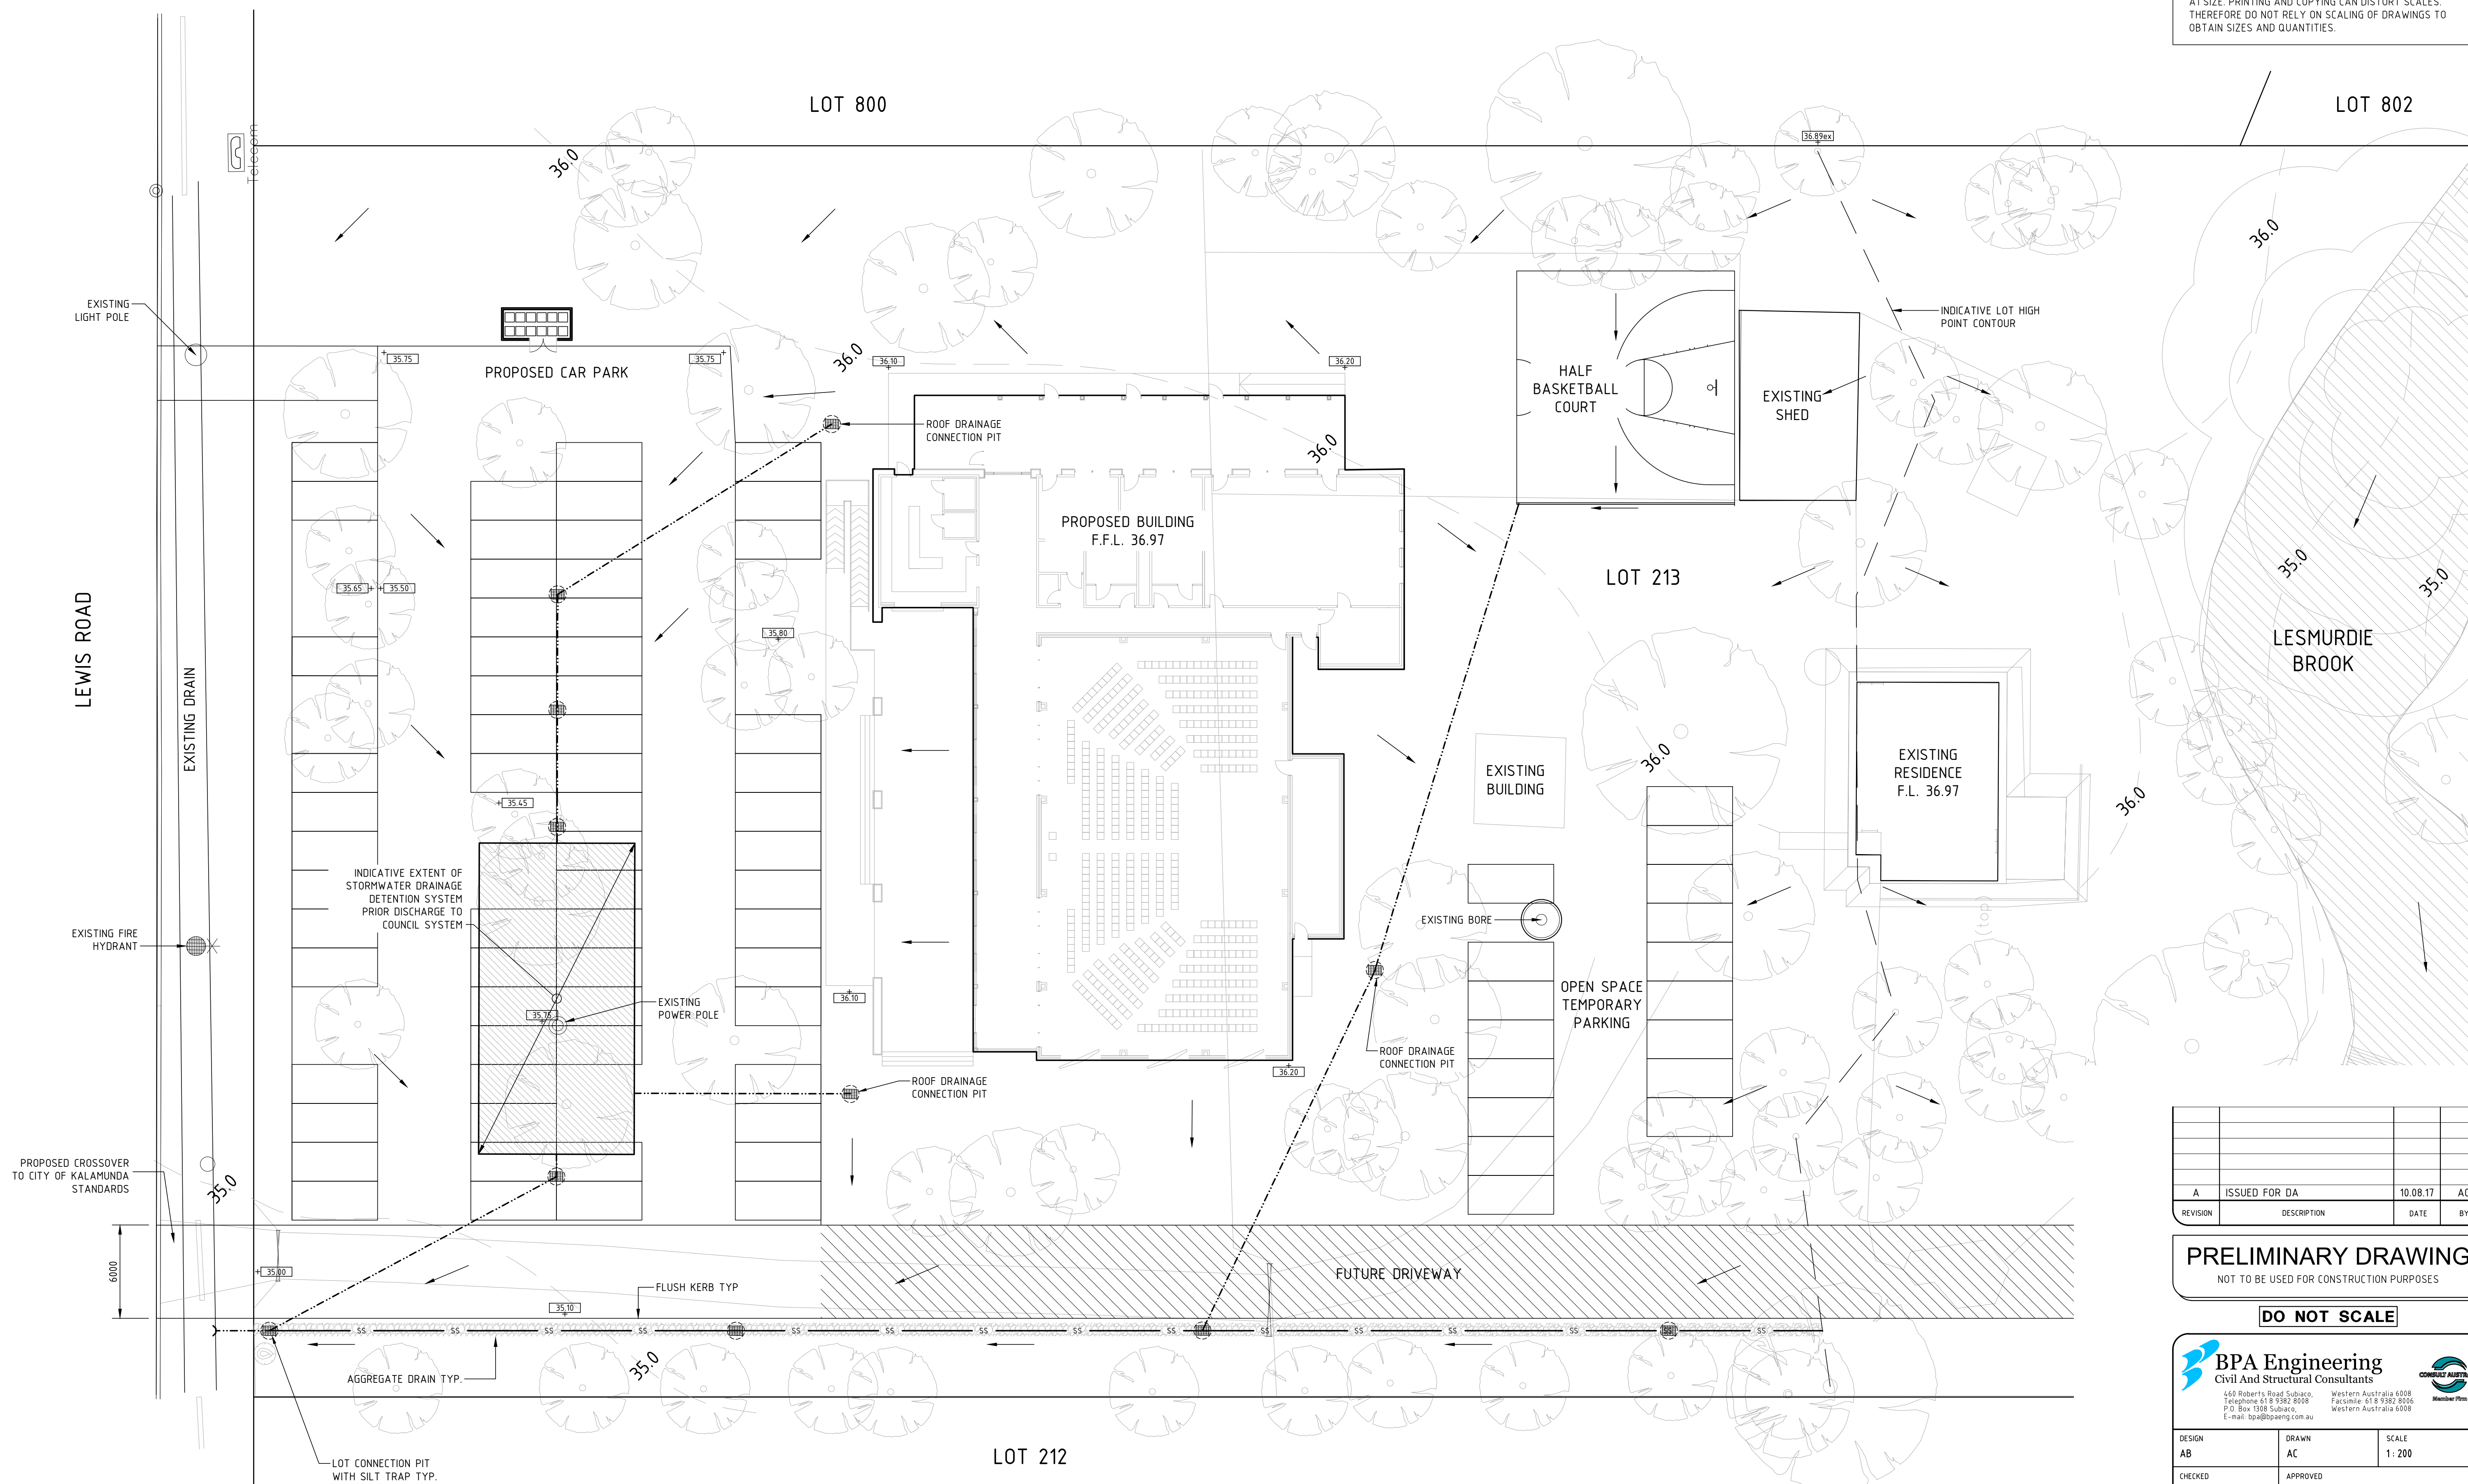

A	ISSUED FOR DA	10.08.17	AC
REVISION	DESCRIPTION	DATE	BY

PRELIMINARY DRAWING

NOT TO BE USED FOR CONSTRUCTION PURPOSES

DO NOT SCALE

 BPA Engineering Civil And Structural Consultants		 COUNCIL OF AUSTRALIA Member Firm	
149 Roberts Road Subiaco, Telephone 08 9382 8008 P.O. Box 1308 Subiaco, E-mail: bpa@bpaeng.com.au		Western Australia 6008 Facsimile 08 9382 8006 Western Australia 6008	
DESIGN AB	DRAWN AC	SCALE 1: 200	
CHECKED	APPROVED		
PETER HUNT ARCHITECT			
COMMUNITY HALL DEVELOPMENT LOT 213 LEWIS ROAD WATTLE GROVE			
STORMWATER DRAINAGE PLAN			
PROJECT NO: S05717		DRAWING C20	
		REV A	

ALL EXISTING & PROPOSED SERVICES SHOWN ARE INDICATIVE. CONTRACTOR TO DETERMINE THE LOCATION & DEPTH OF ALL EXISTING SERVICES PRIOR TO CONSTRUCTION & PROTECT AT ALL TIMES. ANY SERVICE'S LOCATION OR DEPTH FOUND TO BE CONTRARY TO THE DRAWINGS WHICH CAUSES ISSUES OR CLASHES WITH THE CIVIL DESIGN TO BE BROUGHT TO THE ATTENTION OF THE SUPERINTENDENT PRIOR TO CONTINUING WORKS

