

NOT FOR CONSTRUCTION


NOTES
Copyright of this drawing is reserved by HUTCHINSON ASSOCIATES.
This drawing shall only be read in conjunction with all other relevant drawings.
Liaise with all other trades for accurate co-ordination of services.
Site check all dimensions before preparation of working drawing or commencement of work.
This drawing is the property of HUTCHINSON ASSOCIATES and shall be returned at their request.
This drawing shall not be used for any purpose without authority from HUTCHINSON ASSOCIATES.

LEGEND


DS	SEWER DRAIN
SRM	SEWER RISING MAIN
WC	COLD WATER SERVICE
AAV	AIR ADMITTANCE VALVE
CO	CLEANOUT
IV	ISOLATION VALVE
IFW	INDUSTRIAL FLOOR WASTE GULLY
IO	INSPECTION OPENING
HC	15 HOSE COCK WITH VACUUM BREAKER ON WALL 600 ABOVE FFL
HDPE	HIGH DENSITY POLYETHYLENE
RE	ROD END
RSC0	RIISING SHAFT/CLEANOUT
SIZE OF PIPE	
100 DS:60	
GRADE OF PIPE	
TYPE OF SERVICE	

NOTES

- REFER TO ARCHITECT DRAWINGS FOR EXACT LOCATION OF FLOOR WASTE, HWU, TAPWARE, ETC.
- PHYSICALLY VERIFY EXACT LOCATION OF EXISTING SERVICES ON SITE BEFORE COMMENCING ANY NEW WORK.
- RECHECK ALL NOMINATED INVERT LEVELS ON SITE TO AVOID CLASHES WITH STRUCTURAL ELEMENTS AND SERVICES OF OTHER TRADES BEFORE COMMENCING WORK.

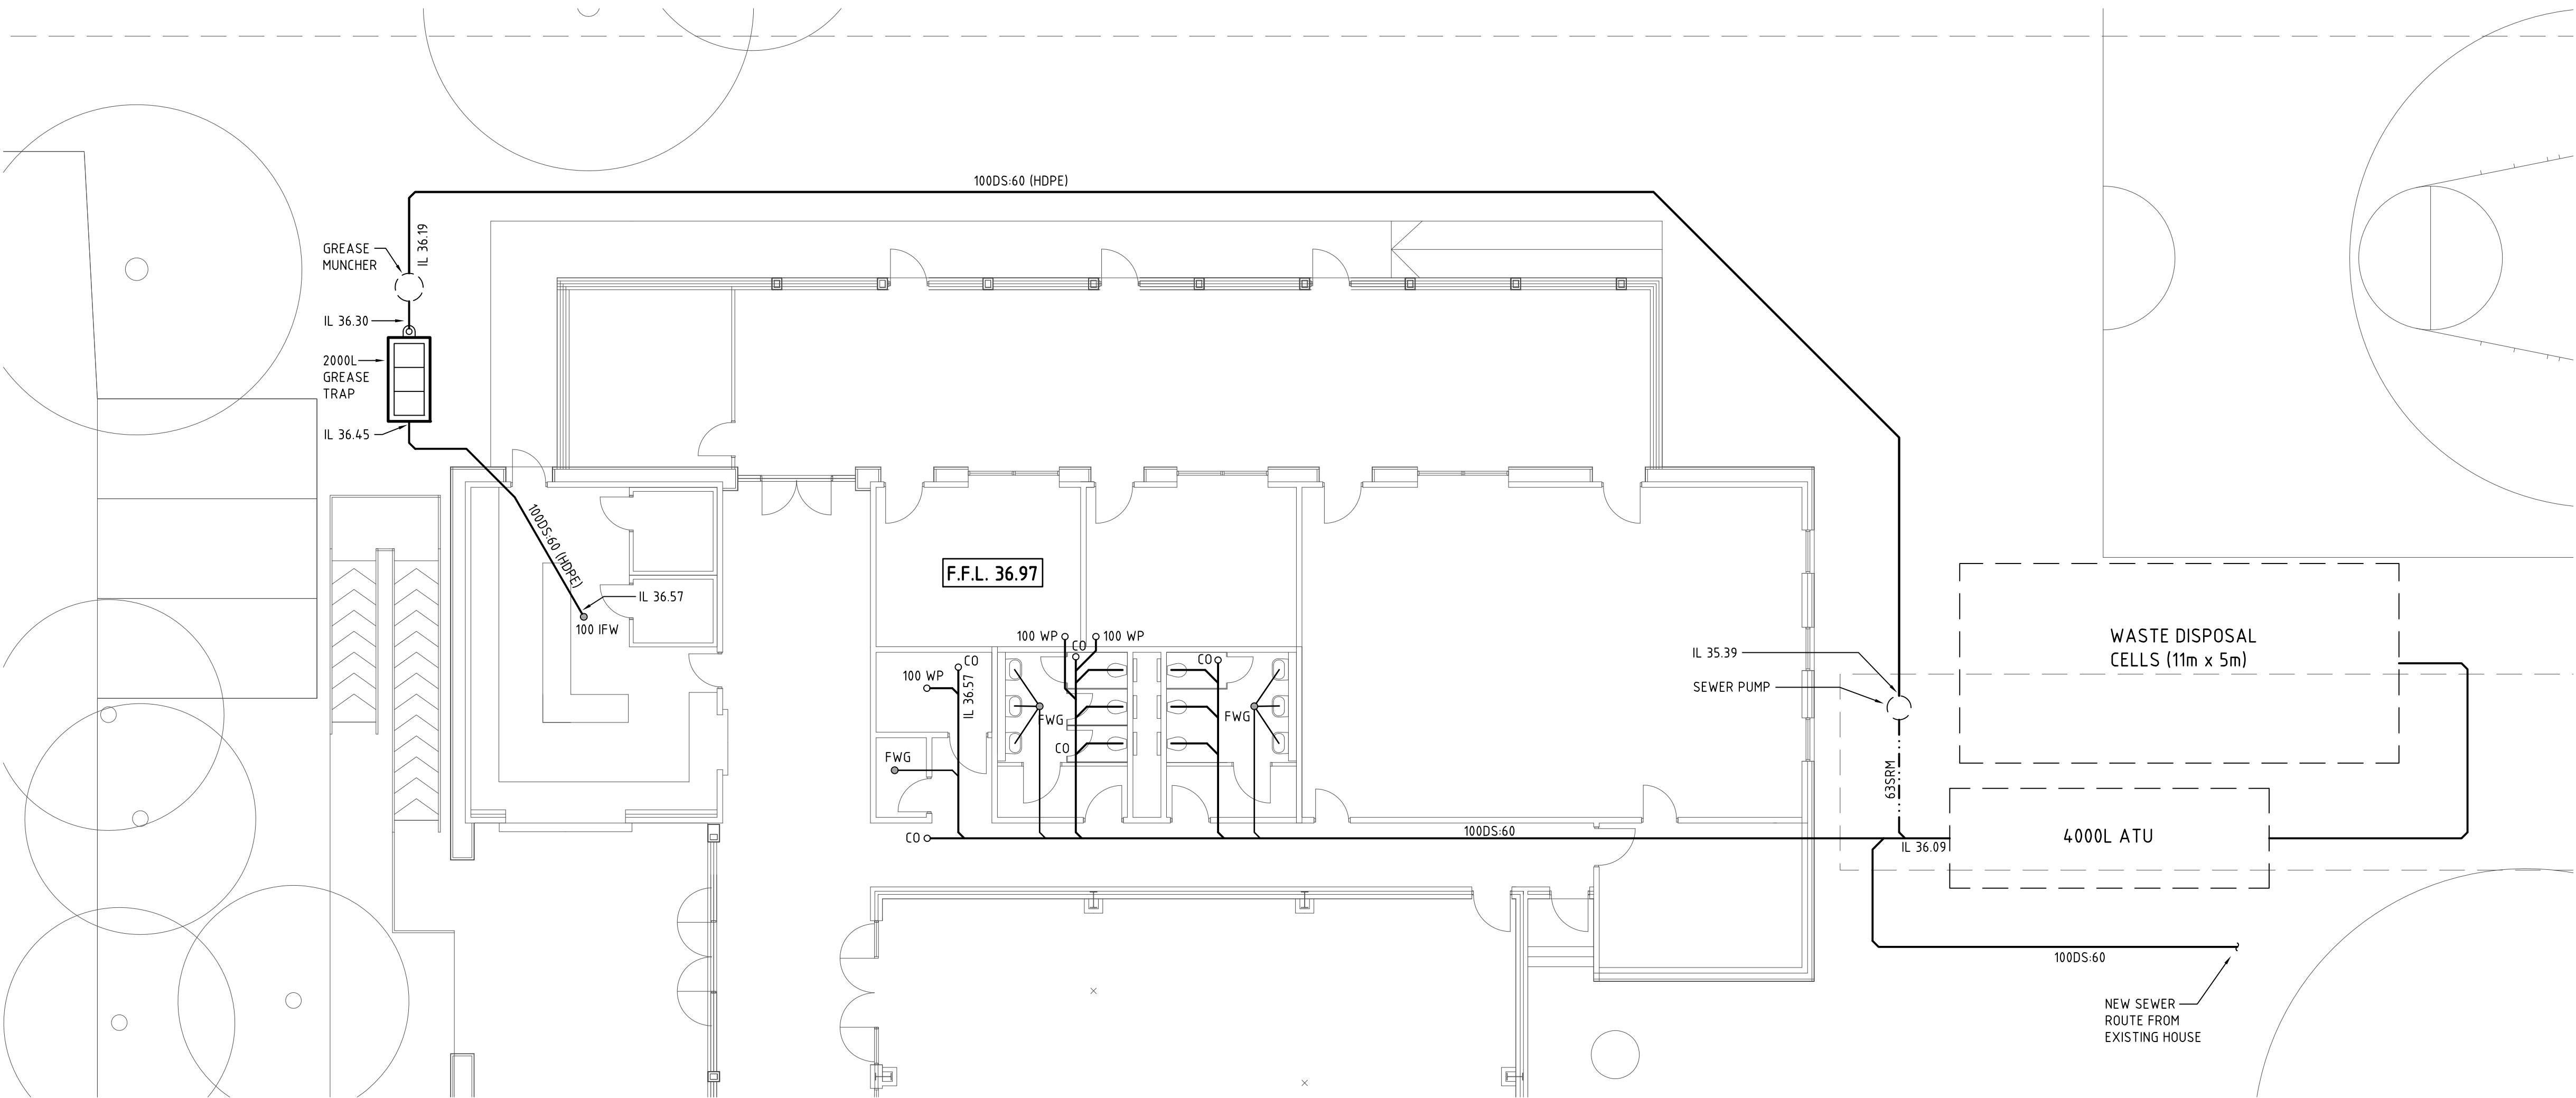

FLOOR PLAN

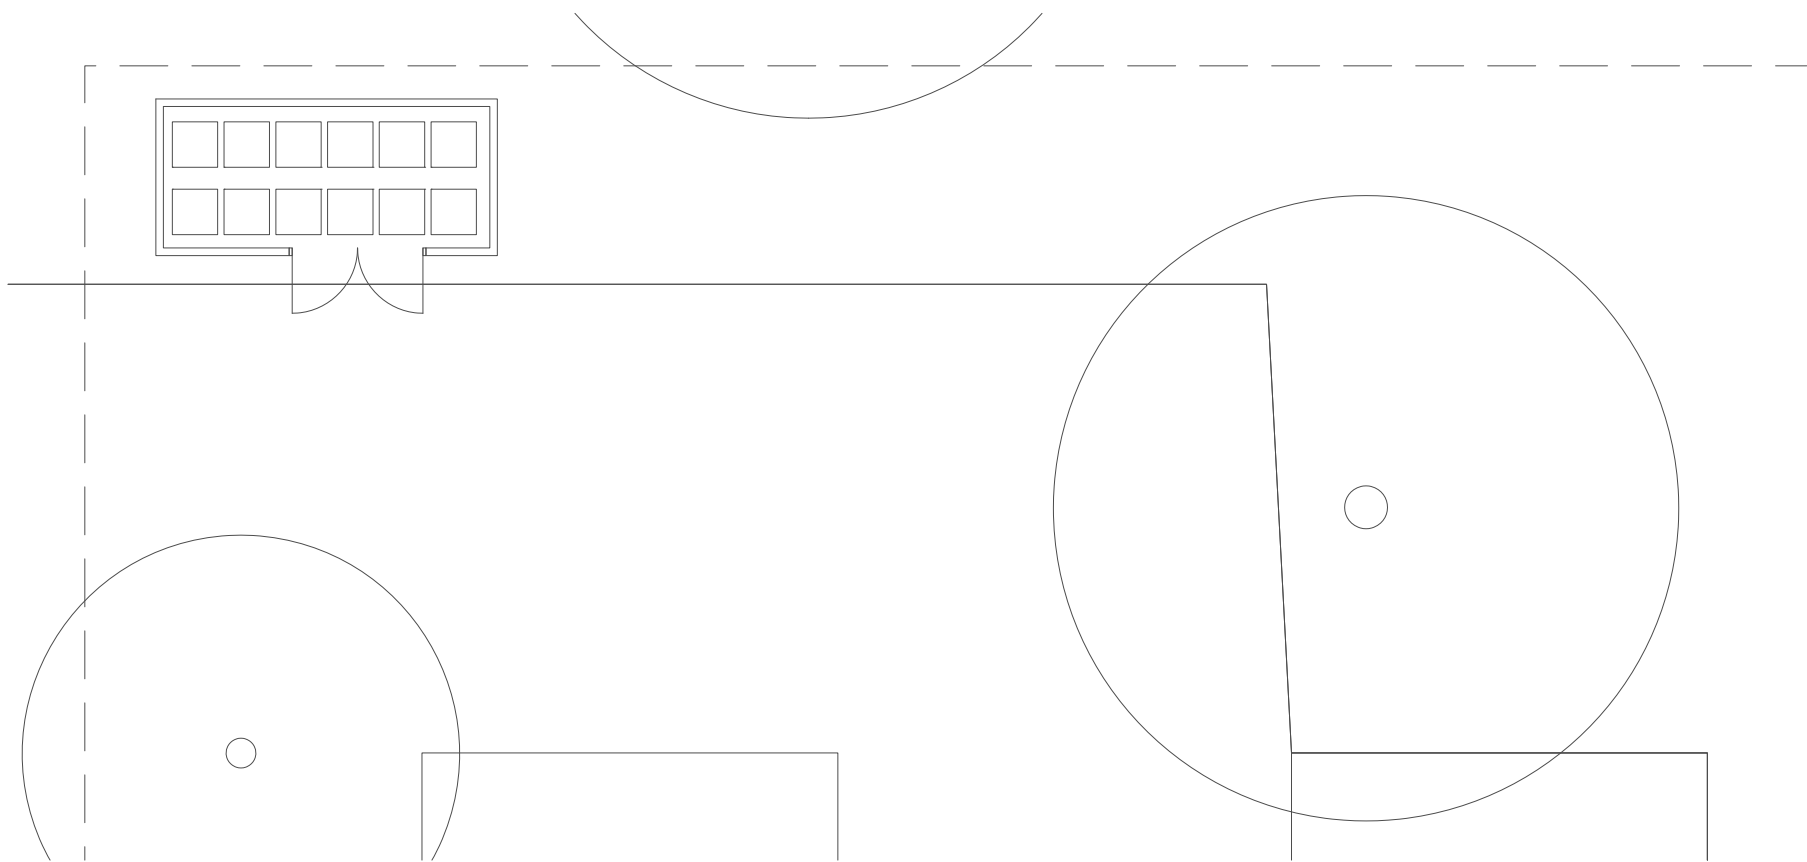

PART PLAN

3	-	27.06.17	THIRD REVIEW	JMD	MAH
2	-	20.06.17	SECOND REVIEW	JMD	MAH
1	-	15.06.17	FIRST REVIEW	JMD	MAH
ISS/REV	DATE	DESCRIPTION	DSN	APP	

Architect
peter hunt architect
Email: pha@phunt.com.au
8 COLIN GROVE, WEST PERTH, WA 6005
TEL: (08) 9322 6033 FAX: (08) 9324 1691

Consultant
Hutchinson Associates
international plumbing & hydraulic consultants
187 Beaufort St. PERTH WA 6000
Telephone: (61.8) 9328 9155
Facsimile: (61.8) 9328 3266
E-Mail: info@hutchass.com.au

Project Title
PLACE OF WORSHIP & COMMUNITY USE
LOT 213 (28) LEWIS ROAD
WATTLEGROVE

Drawing Title
HYDRAULIC SERVICES
SEWER DRAINAGE

Date	JUNE17	Drawn	JMD	Designed	JMD	
Scale	1:100	Sheet Size	A1	Checked	MAH	
Project No.	72.17	Drawing No.	SK-01	Issue	3	

7217H001.DWG 7/08/2017 9:42:53 AM

